

3. Furniture Schedule


#	Door Size	Manufacturer	Ordered From	Count	Description
21	30" X 35"	DUKE	DAI	1	30" HIGH X 35" WIDE SWING GATE. BEIGEWOD LAMINATE (7850-60) FINISH. INSTALLED BY G.C.
07	36" x 80"	LOCAL	G.C.	1	SOLID CORE HARDWOOD DOOR (SLAB OR PANEL CONSTRUCTION). METAL FRAME WITH CLEAR ANODIZED ALUMINUM LEVER HANDLE. PAINT DOOR AND FRAME WITH BENJAMIN MOORE "YELLOW GREEN" #2033-10, 793-4X ADVANCE. SEMI-GLOSS FINISH.
)7A	36" x 80"	LOCAL	G.C.	2	SOLID CORE HARDWOOD DOOR (SLAB OR PANEL CONSTRUCTION) METAL FRAME WITH CLEAR ANODIZED ALUMINUM LEVER HANDLE. PAINT DOOR AND FRAME WITH SHERWIN WILLIAMS GOSSAMER VEIL (SW#9165) SEMI-GLOSS FINISH.

4. Door Schedule

## 6. Floor Schedule

NOTE: THE SUBWAY STORE DESIGN DEPARTMENT WILL NOT ACCEPT RESPONSIBILITY FOR ANY INACCURACIES. THE CALCULATIONS PROVIDED BELOW MUST BE VERIFIED BY THE G.C. AND FRANCHISE OWNER BEFORE ANY ORDER FOR THESE MATERIALS IS ACCEPTED AND PLACED.

568.19 ft<sup>2</sup> OPTION 1: CROSSVILLE, "SILVER SANDS" 12" X 24" PORCELAIN FLOOR TILES, COLOR; AD-126-2, 3/16" THICK GROUT LINES, LATICRETE PERMACOLOR SELECT: CEMENTITOUS GROUT. COLOR: 35 MOCHA. OPTION 2: PORCELANOSA, "LINKFLOOR PICCADILLY" LVT. 12" X 24" RESTROOMS PORCELANOSA X 1/4" THICK. HEAVY DUTY WATERPROOF OVERLAY ON SELF ADHESIVE MEMBRANE, INSTALLED BY G.C.

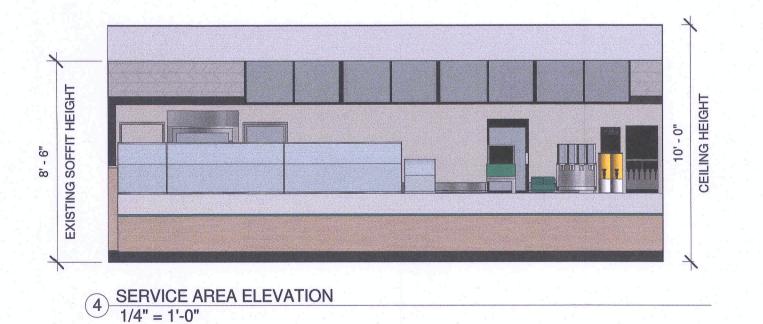

Ordered From Area

Manufacturer

## SYMBOL LEGEND

Description

- 120V DUPLEX OUTLET

 220V SINGLE OUTLET - ELECTRIC PANEL

- PHONE JACK ▼ - DATA JACK

c.m. - CEILING MOUNTED

F.M. - FLOOR MOUNTED JUNCTION BOX

LOCAL CODE. - THERMOSTAT

## **FRESH START LOCATION**

ONE ELECTRICAL JUNCTION BOX TO BE LOCATED IN CEILING ABOVE EACH

- CUNO MODEL SW260-PLUS WATER FILTRATION SYSTEM IS REQUIRED IN ALL NEW STORES THAT DISPENSE BEVERAGES. THE RECOMMENDED PLACEMENT FOR INSTALLATION IS MOUNTED TO SODA SYRUP RACK BY COCA-COLA. SECONDARY PLACEMENT OPTION IS MOUNTED ON THE BACKROOM WALL. THIRD INSTALLATION OPTION IS MOUNTING INSIDE THE FRONT BEVERAGE COUNTER WHEN SPACE LIMITATIONS OCCUR, REQUIRED: 1/2" INCOMING WATER LINE FEED WITH 1/2" BAI VALVE SHUTOFF AND 1/2" FPT CONNECTION. MINIMUM 110 VOLT, 20 AMP ELECTRICAL SERVICE TO SUPPORT THE CARBONATOR AND WATER BOOSTER (MUST BE DEDICATED CIRCUIT).
- EXIT LIGHTS INSTALLED BY G.C. PER LOCAL CODE. EMERGENCY LIGHTS INSTALLED BY G.C. PER LOCAL CODE.

EXTINGUISHERS, SMOKE AND FIRE DETECTION SYSTEMS INSTALLED BY G.C. PER

- LABOR & MATERIAL SUPPLIED BY G.C. UNLESS OTHERWISE NOTED.
- ALL DIMENSIONS TO BE VERIFIED BY G.C. ON SITE.
- REFRIGERATOR AND FREEZER MUST BE ADEQUATELY VENTILATED. REFER TO MANUFACTURER FOR DETAILS.

	1000
THIS DRAWING IS FURNISHED BY FWH ON BEHALF OF SUBWAY IP, LLC. ("SIP") D/B/A SUBWAY. RECIPIENT MUST DETERMINE IF THIS DRAWING MUST BE SUBMITTED TO A LICENSED ARCHITECT OR SIMILAR PROFESSIONAL UNDER FEDERAL, STATE OR LOCAL LAW. ANY CHANGES MUST BE APPROVED BY SIP.	
DO NOT SCALE DRAWING. WRITTEN DIMENSIONS TAKE PRECEDENCE OVER SCALED DIMENSIONS. AND SHALL BE VERIFIED IN THE FIELD BY THE GENERAL CONTRACTOR AND/OR FRANCHISEE/OWNER. ANY DISCREPANCY IN DIMENSIONS SHALL BE BROUGHT TO THE IMMEDIATE ATTENTION OF YOUR AREA DEVELOPMENT AGENT OR DESIGNATED FIELD REPRESENTATIVE.	
THE GENERAL CONTRACTOR AND EACH SUB-CONTRACTOR SHALL MAKE HIS OWN INSPECTIONS AND MEASUREMENTS, FWH AND SIP SHALL NOT BE HELD RESPONSIBLE FOR THE ACCURACY OF DIMENSIONS AND FOR ERRORS AND OMISSIONS IN THE DRAWINGS IF WRITTEN CONFIRMATION HAD NOT BEEN RECEIVED BY THE FWH STORE DESIGN DEPARTMENT.	
THIS DRAWING AND THE INFORMATIONAL CONTENT HERE OF IS THE CONFIDENTIAL PROPERTY OF SIP AND IS PROVIDED SOLELY FOR THE USE OF AUTHORIZED FRANCHISEES, THEIR AGENTS AND CONTRACTORS. RECIPIENT AGREES NOT TO REPRODUCE, COPY, USE OR TRANSMIT THIS DRAWING AND/OR ITS INFORMATIONAL CONTENT, IN WHOLE OR IN PART, OR TO ALLOW SUCH ACTION BY OTHERS, FOR ANY PURPOSE, EXCEPT WITH THE WRITTEN PERMISSION OF SIP OR FWH ACTING ON BEHALF OF SIP. RECIPIENT FURTHER AGREES TO SURRENDER THIS DRAWING AND ANY PERMITTED COPIES HEREOF UPON DEMAND.	

DIMENSION & ELECTRICAL PLAN

1/4" = 1'-0"

DESIGNED BY: Saisystems **REVISIONS** NO. DATE **DESCRIPTION DRAWN BY** DAN BOURQUE **REVIEWED BY:** RESTAURANT MUST BE CONSTRUCTED AS DESIGNED IN THESE FLOOR PLANS SUBJECT TO FEDERAL, STATE AND LOCAL

LAWS. RECIPIENT IS RESPONSIBLE FOR ENSURING COMPLIANCE WITH ALL LAWS. IF MODIFICATIONS ARE NECESSARY,

PLEASE CONTACT THE FWH STORE DESIGN DEPARTMENT FOR WRITTEN APPROVAL OF THE REQUIRED CHANGES.

**RESTAURANT#:** 6958

**ADDRESS:** 

DATE:

OC TOBER 11, 2019

30979 5 Mile Livonia

MI United States 48154

**DEVELOPMENT AGENT:** 

Zaid Elia

FRANCHISEE:

Brad Turowski



- DIGITAL MEDIA PLAYER

WORLD HEADQUARTERS 325 SUB WAY MILFORD, CT 06461

(203) 877-4281 (800)888 - 4848 SCALE:

SHEET #:

As indicated © 2018 SUBWAY IP, LLC.